

SPECIAL UNIT PRINT
 I HEREBY CERTIFY THAT I HAVE
 THOROUGHLY REVIEWED THIS CONSTRUCTION
 PRINT AND CONFIRM THAT IT IS CORRECT


DEALER : _____
 CUSTOMER : _____
 DATE : _____

SPECIAL UNIT FOR
 DEALER: CABRILLO
 CUSTOMER: LOT 8 (SPEC)
 ACTUAL DIMENSIONS OF HOME
 13'-4" x 50'-0"



SITE 8

LIGHT & VENT SCHEDULE			
NAME	AREA	REQ'D LIGHT	REQ'D VENT
DINING	41.79	3.34	1.67
LIVING	122.49	9.80	4.90
MASTER BEDROOM	137.78	11.02	5.51

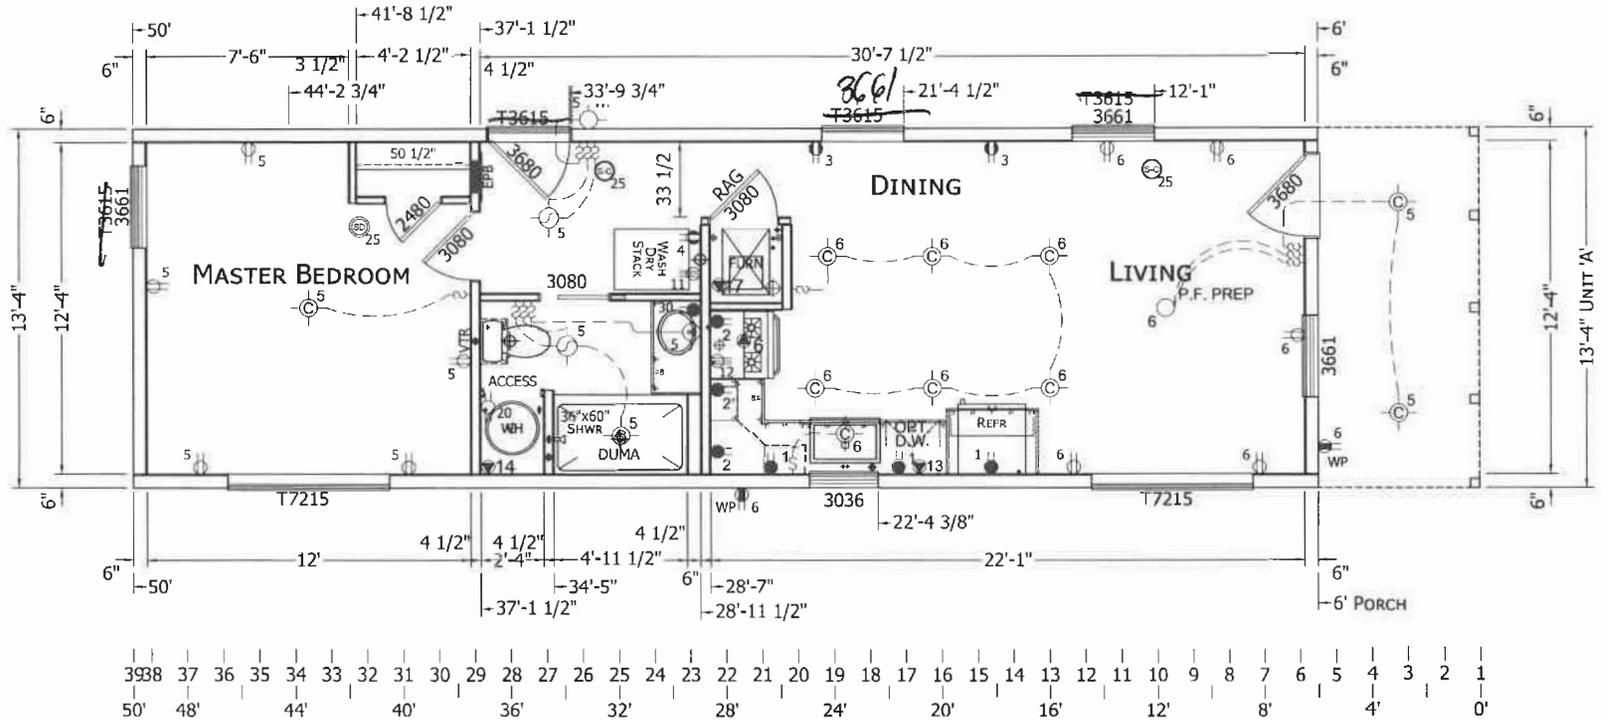

755 W. BIG BRAVER ROAD, SUITE 1000 TROY, MI 48064
 PHONE: 248-614-8200

MODIFICATIONS

PROJECT: 05-1450 HUD
 50'-0" x 13'-4"
 1 BD 1 BT

DRAWN BY: STAFF
 DATE: 05-15-24
 SCALE: 5/32" = 1'-0"

TITLE: FLOOR PLAN
 ELECTRICAL PLAN

FILENAME: 05-1450 HUD CABRILLO - LOT 8 (SPEC)

SHEET: AP-101

PROPRIETARY AND CONFIDENTIAL.
 THESE DRAWINGS AND SPECIFICATIONS ARE ORIGINAL.
 PROPRIETARY AND CONFIDENTIAL MATERIALS OF CHAMPION.
 COPYRIGHT © 1976-2024 BY CHAMPION